



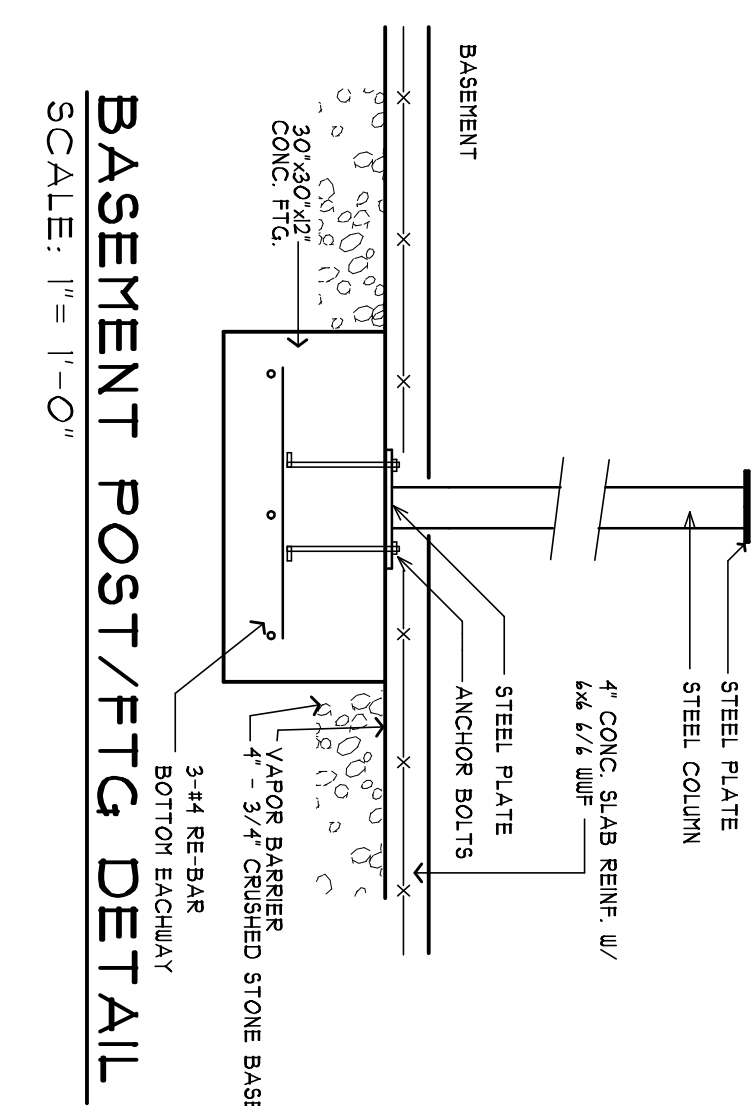

BASEMENT POST/FTG DETAIL


SCALE: 1" = 1'-0"

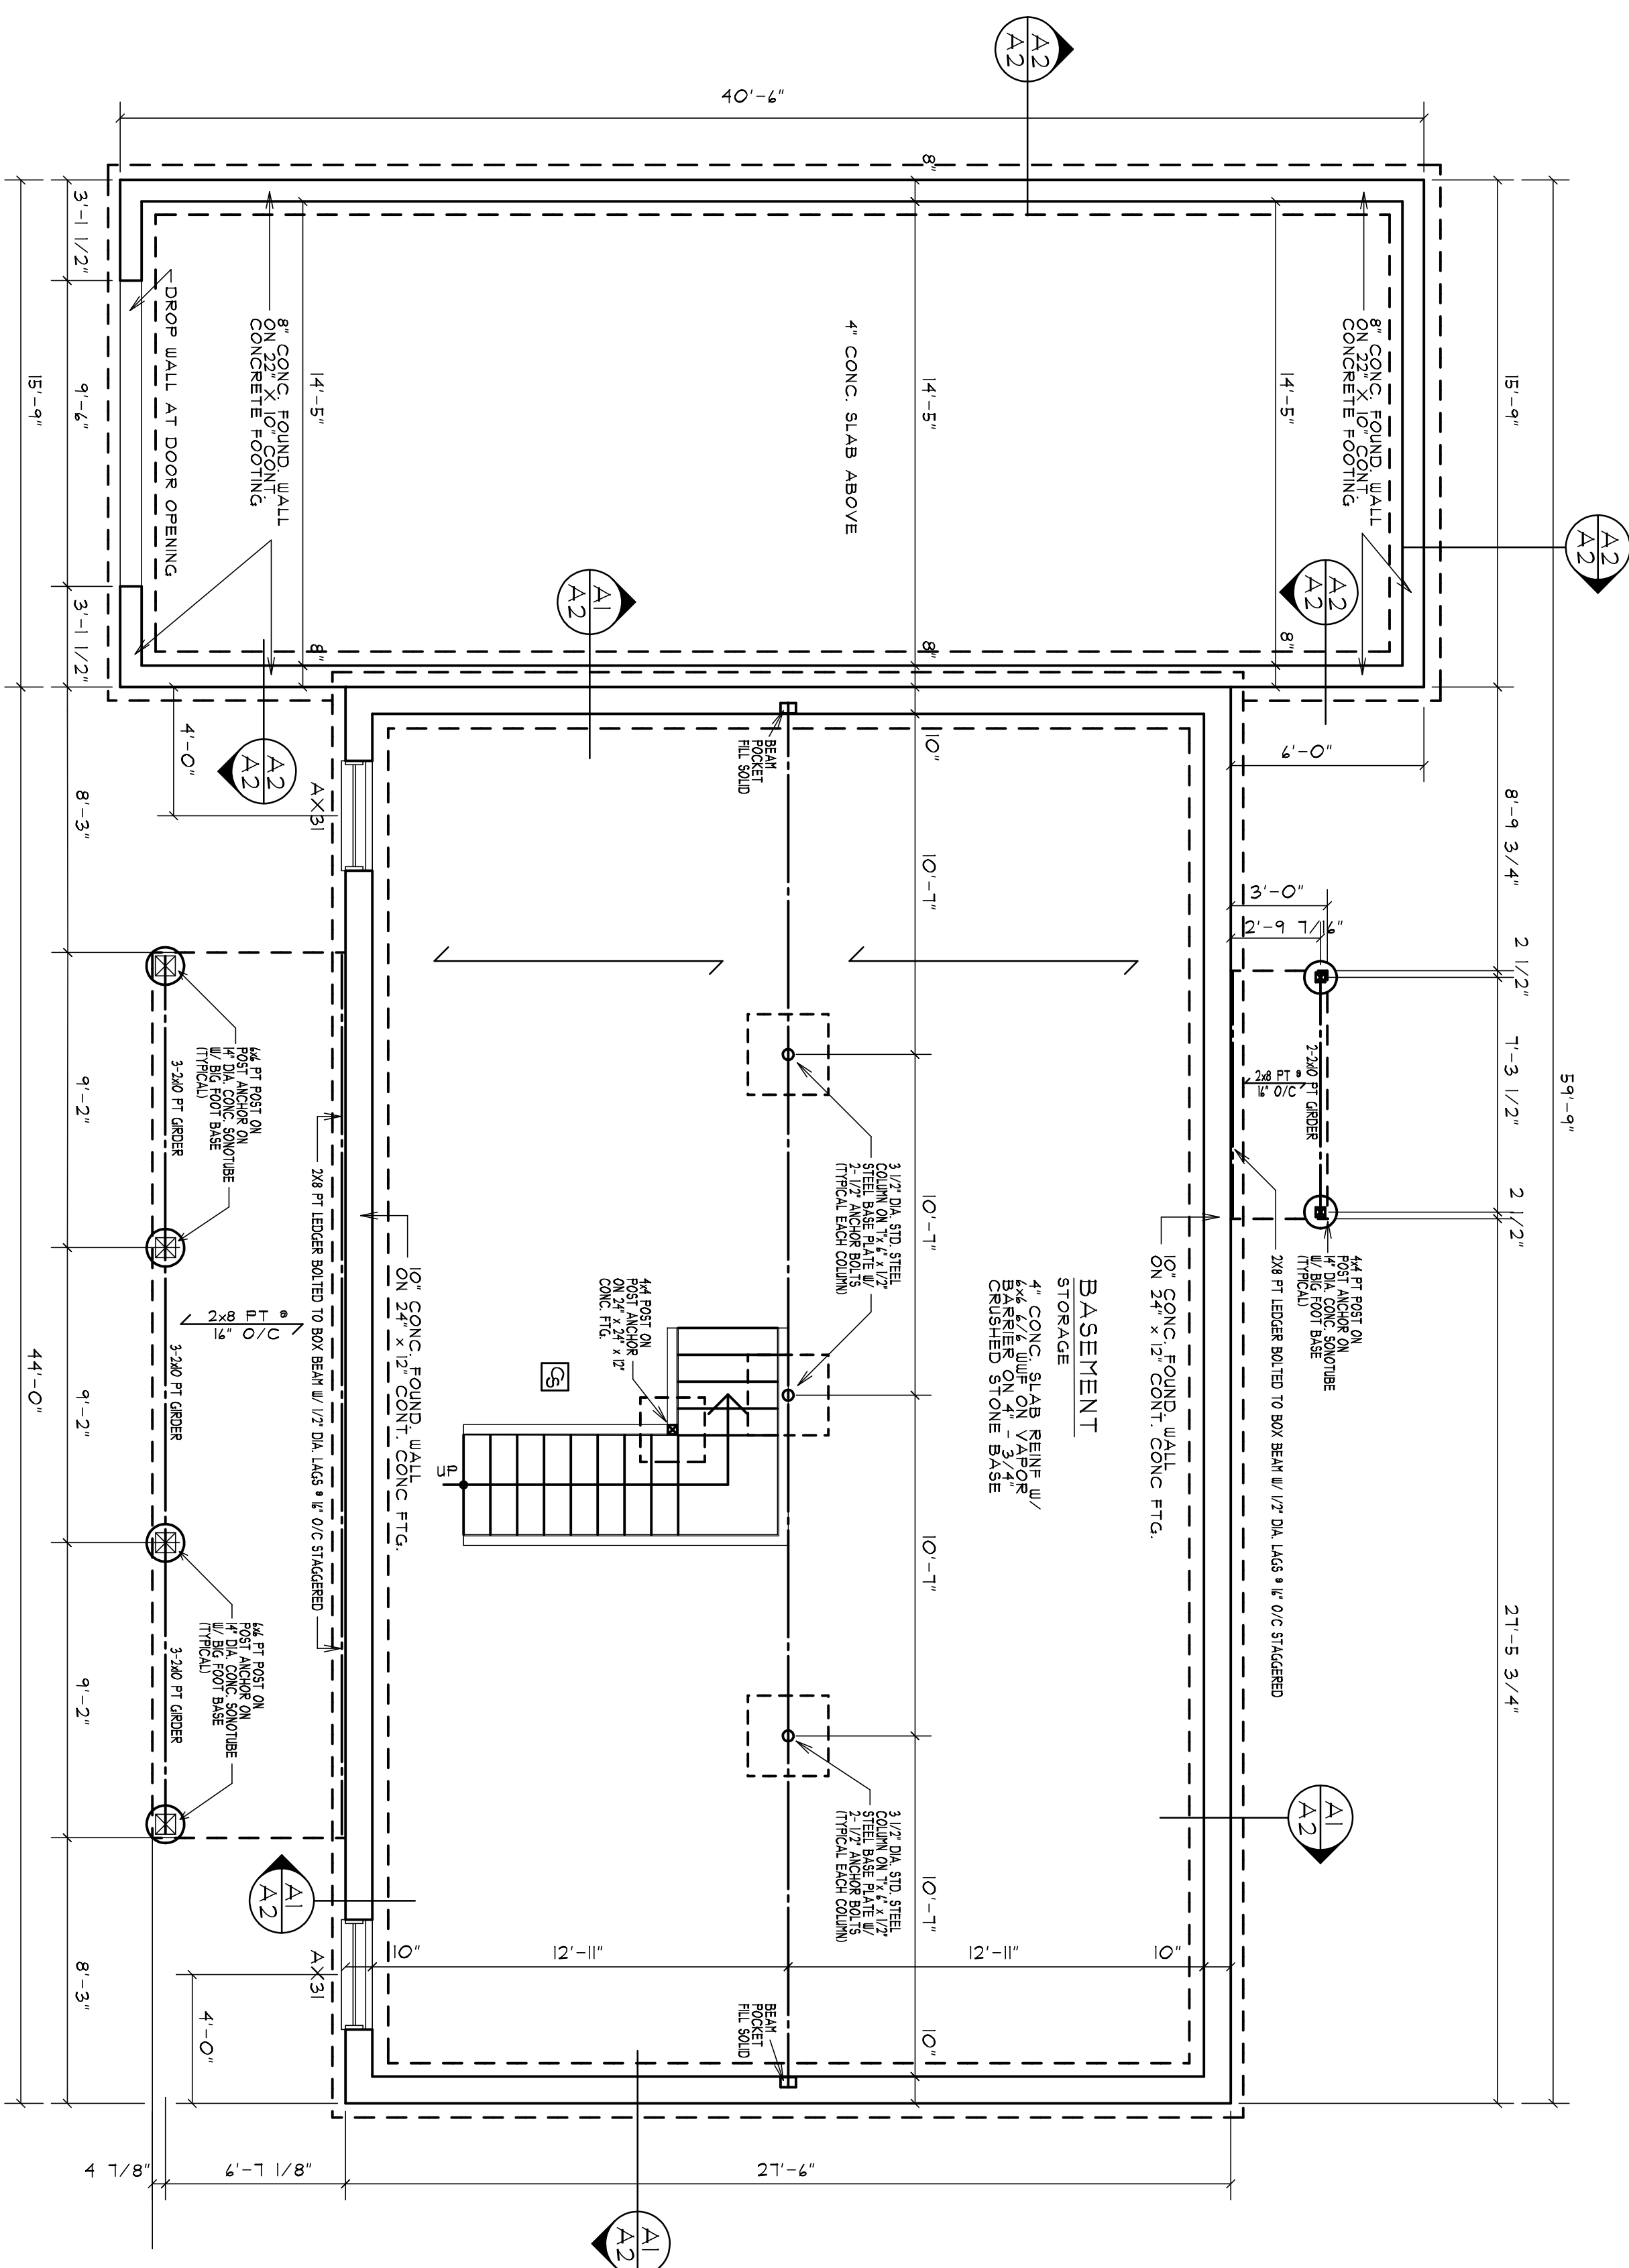


BASEMENT / FOUNDATION PLAN

SCALE: 1/4" = 1'-0"


-  INDICATES CARBON MONOXIDE DETECTOR
HARD WIRED WITH BATTERY BACK-UP
WITH A SMOKE AND HEAT DETECTOR
HARD WIRED WITH BATTERY BACK-UP
INTEGRATED INTO THE SAME SYSTEM

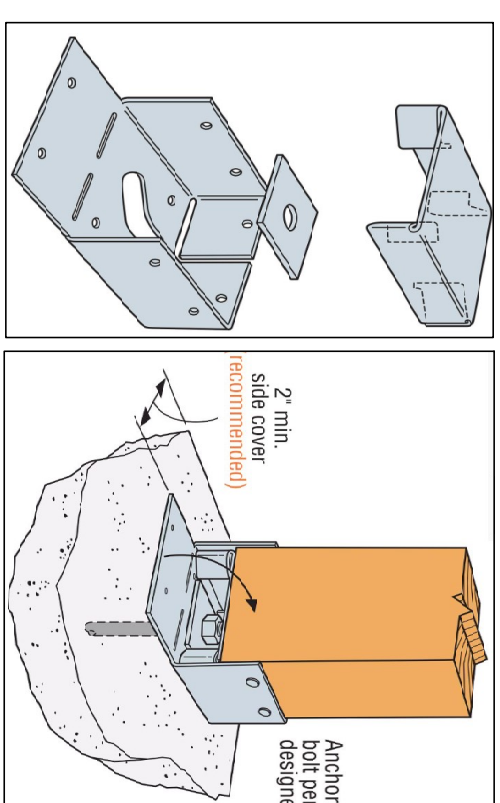

POST BASE DETAIL

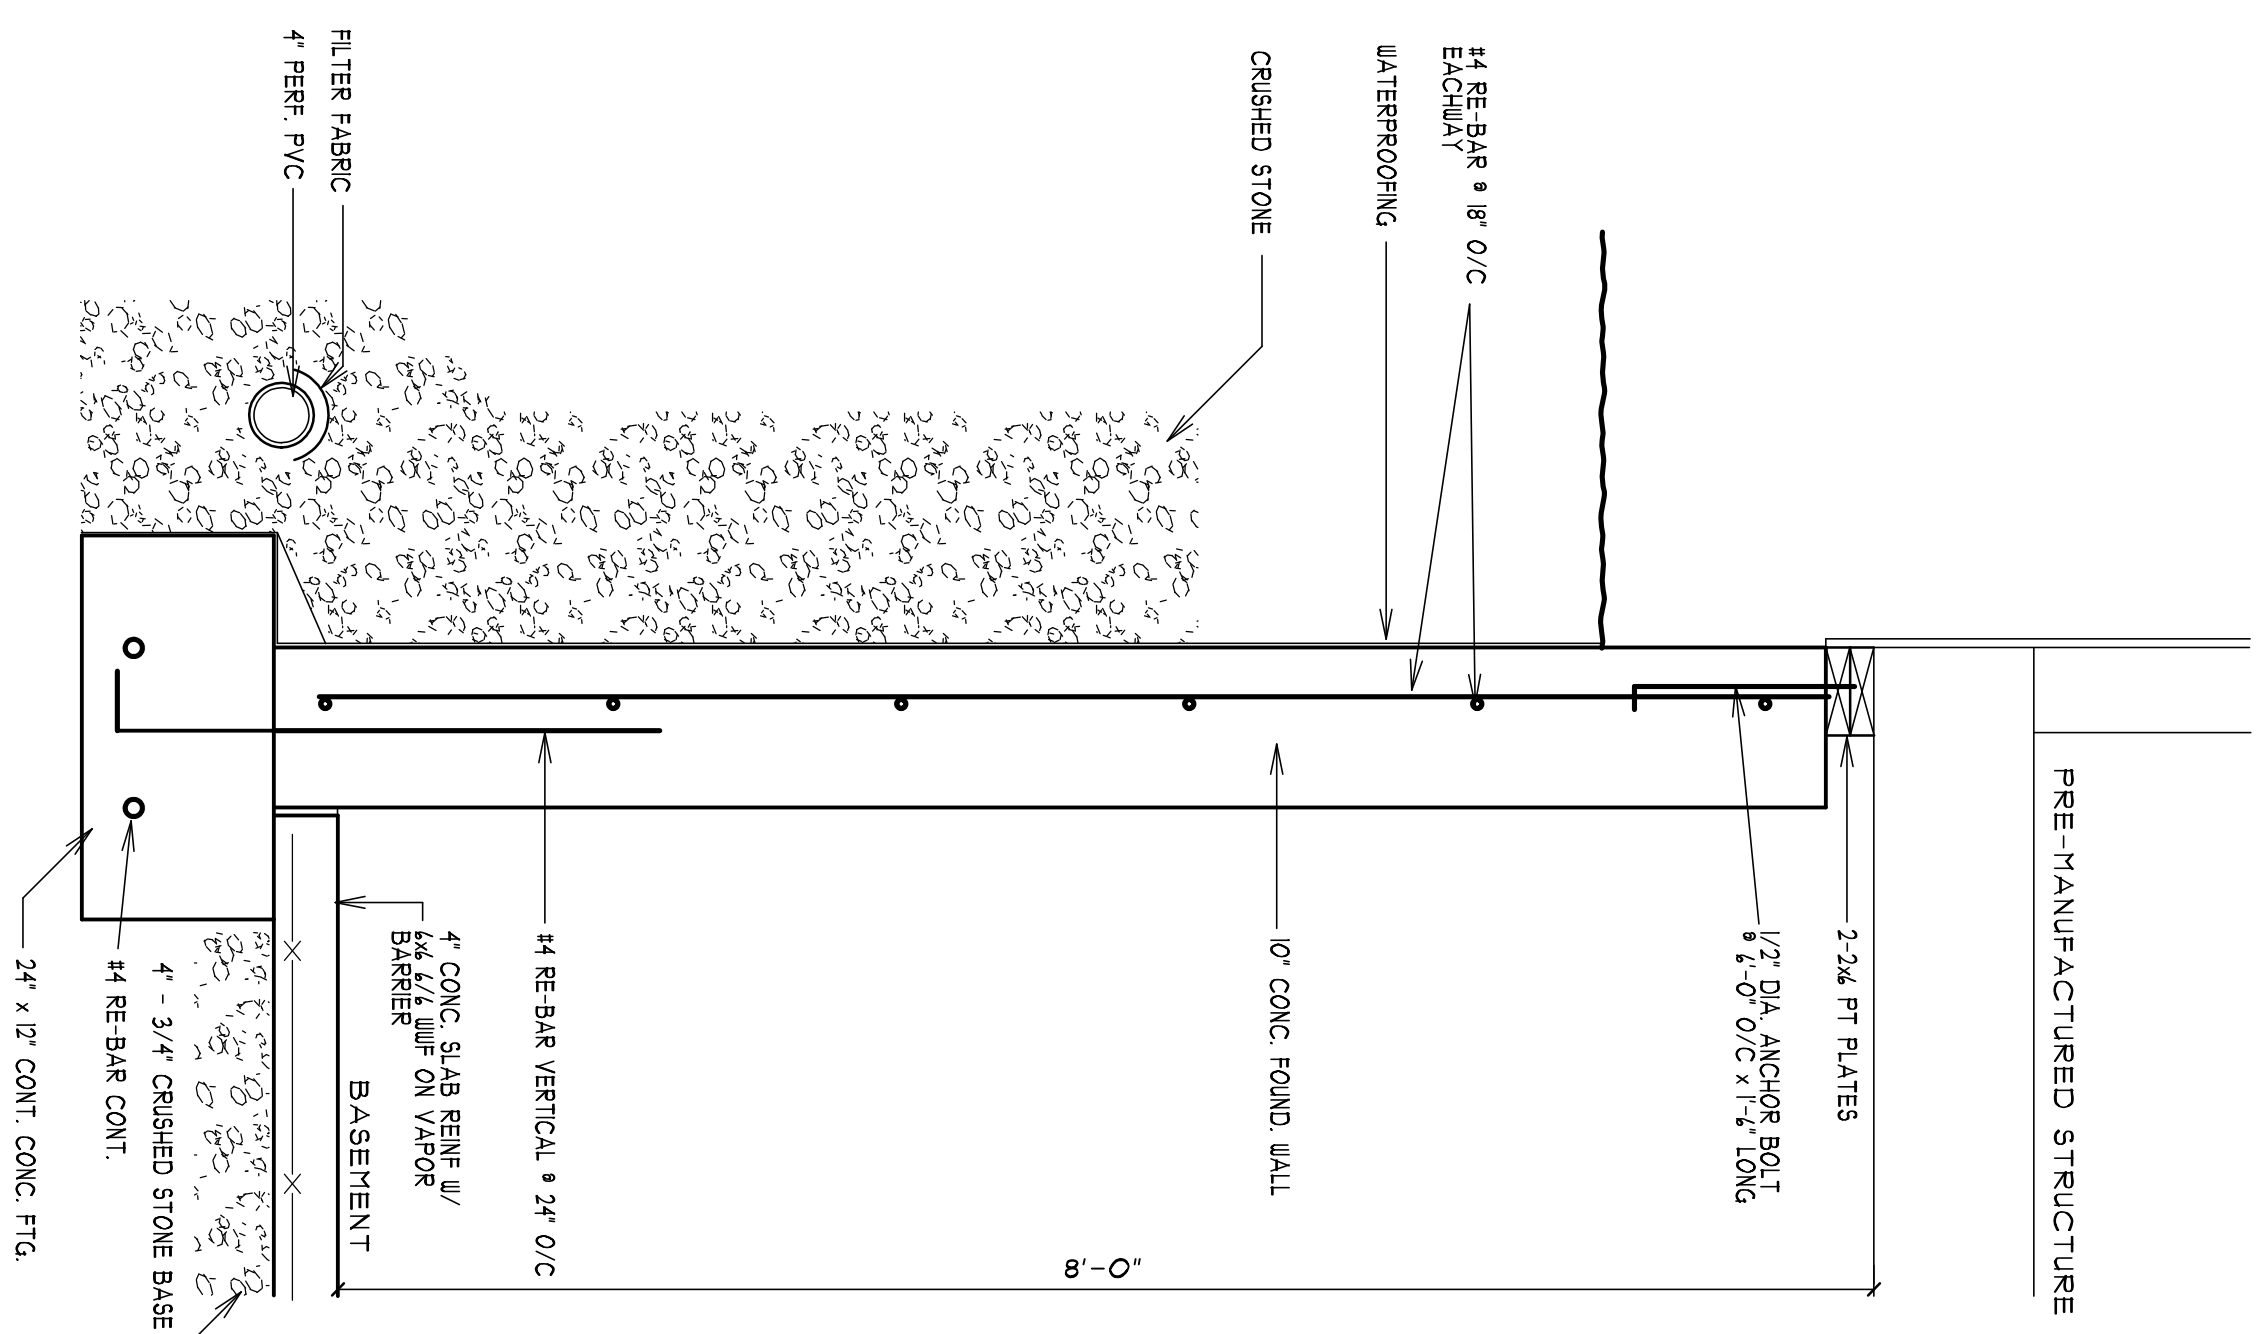

FOUNDATION WALL DETAIL

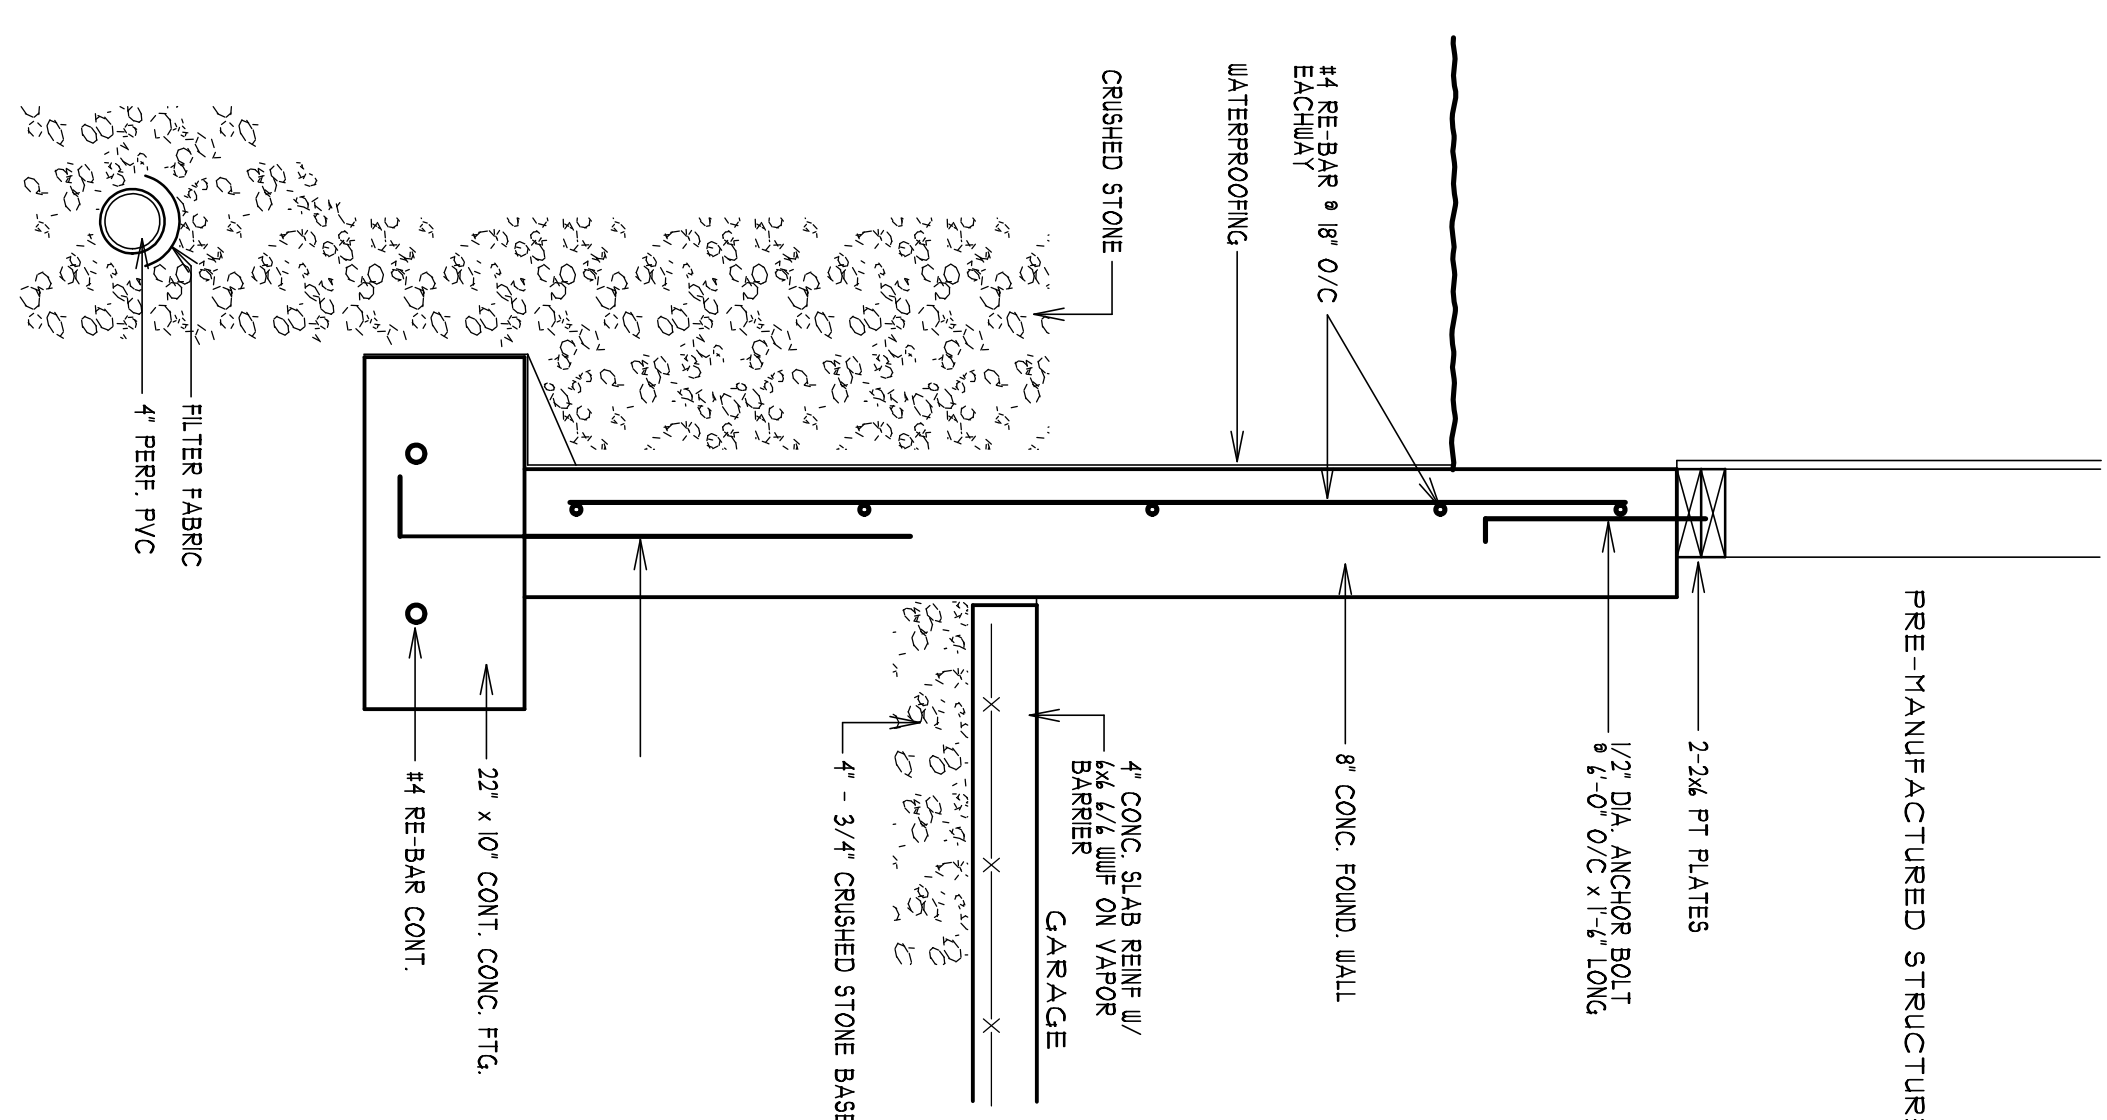

A2 FOUNDATION WALL DETAIL

[illegible]

